

LOCUS MAP


SCALE: 1"=1,000'±

LOCUS: ASSESSORS MAP 123 - LOT 120

OWNER: GRAHAM & HUNT LIMITED
LIABILITY COMPANY
978 NASH ROAD
NEW BEDFORD, MA 02746

DEED REFERENCE: BOOK 4672, PAGE 164


LEGEND			
	PROPERTY LINE	CB □	CATCH BASIN
	BUILDING ENTRANCE	DMH ○	DRAIN MANHOLE
	EXISTING CONTOUR	SMH ○	SEWER MANHOLE
	DOUBLE YELLOW LINE	GG ○	GAS GATE VALVE
	CHAIN LINK FENCE	UP ○	UTILITY POLE
	OVERHEAD WIRES	MW ○	MONITORING WELL
	GAS MAIN	104 43	EXISTING SPOT GRADE
	WATER MAIN	LP ○	LIGHT POLE
	SEWER LINE	DS ○	DOWN SPOUT
	DRAINAGE LINE	WF-115 WF-116	EDGE OF BORDERING VEGETATED WETLANDS
	NUMBER OF PARKING SPACES		

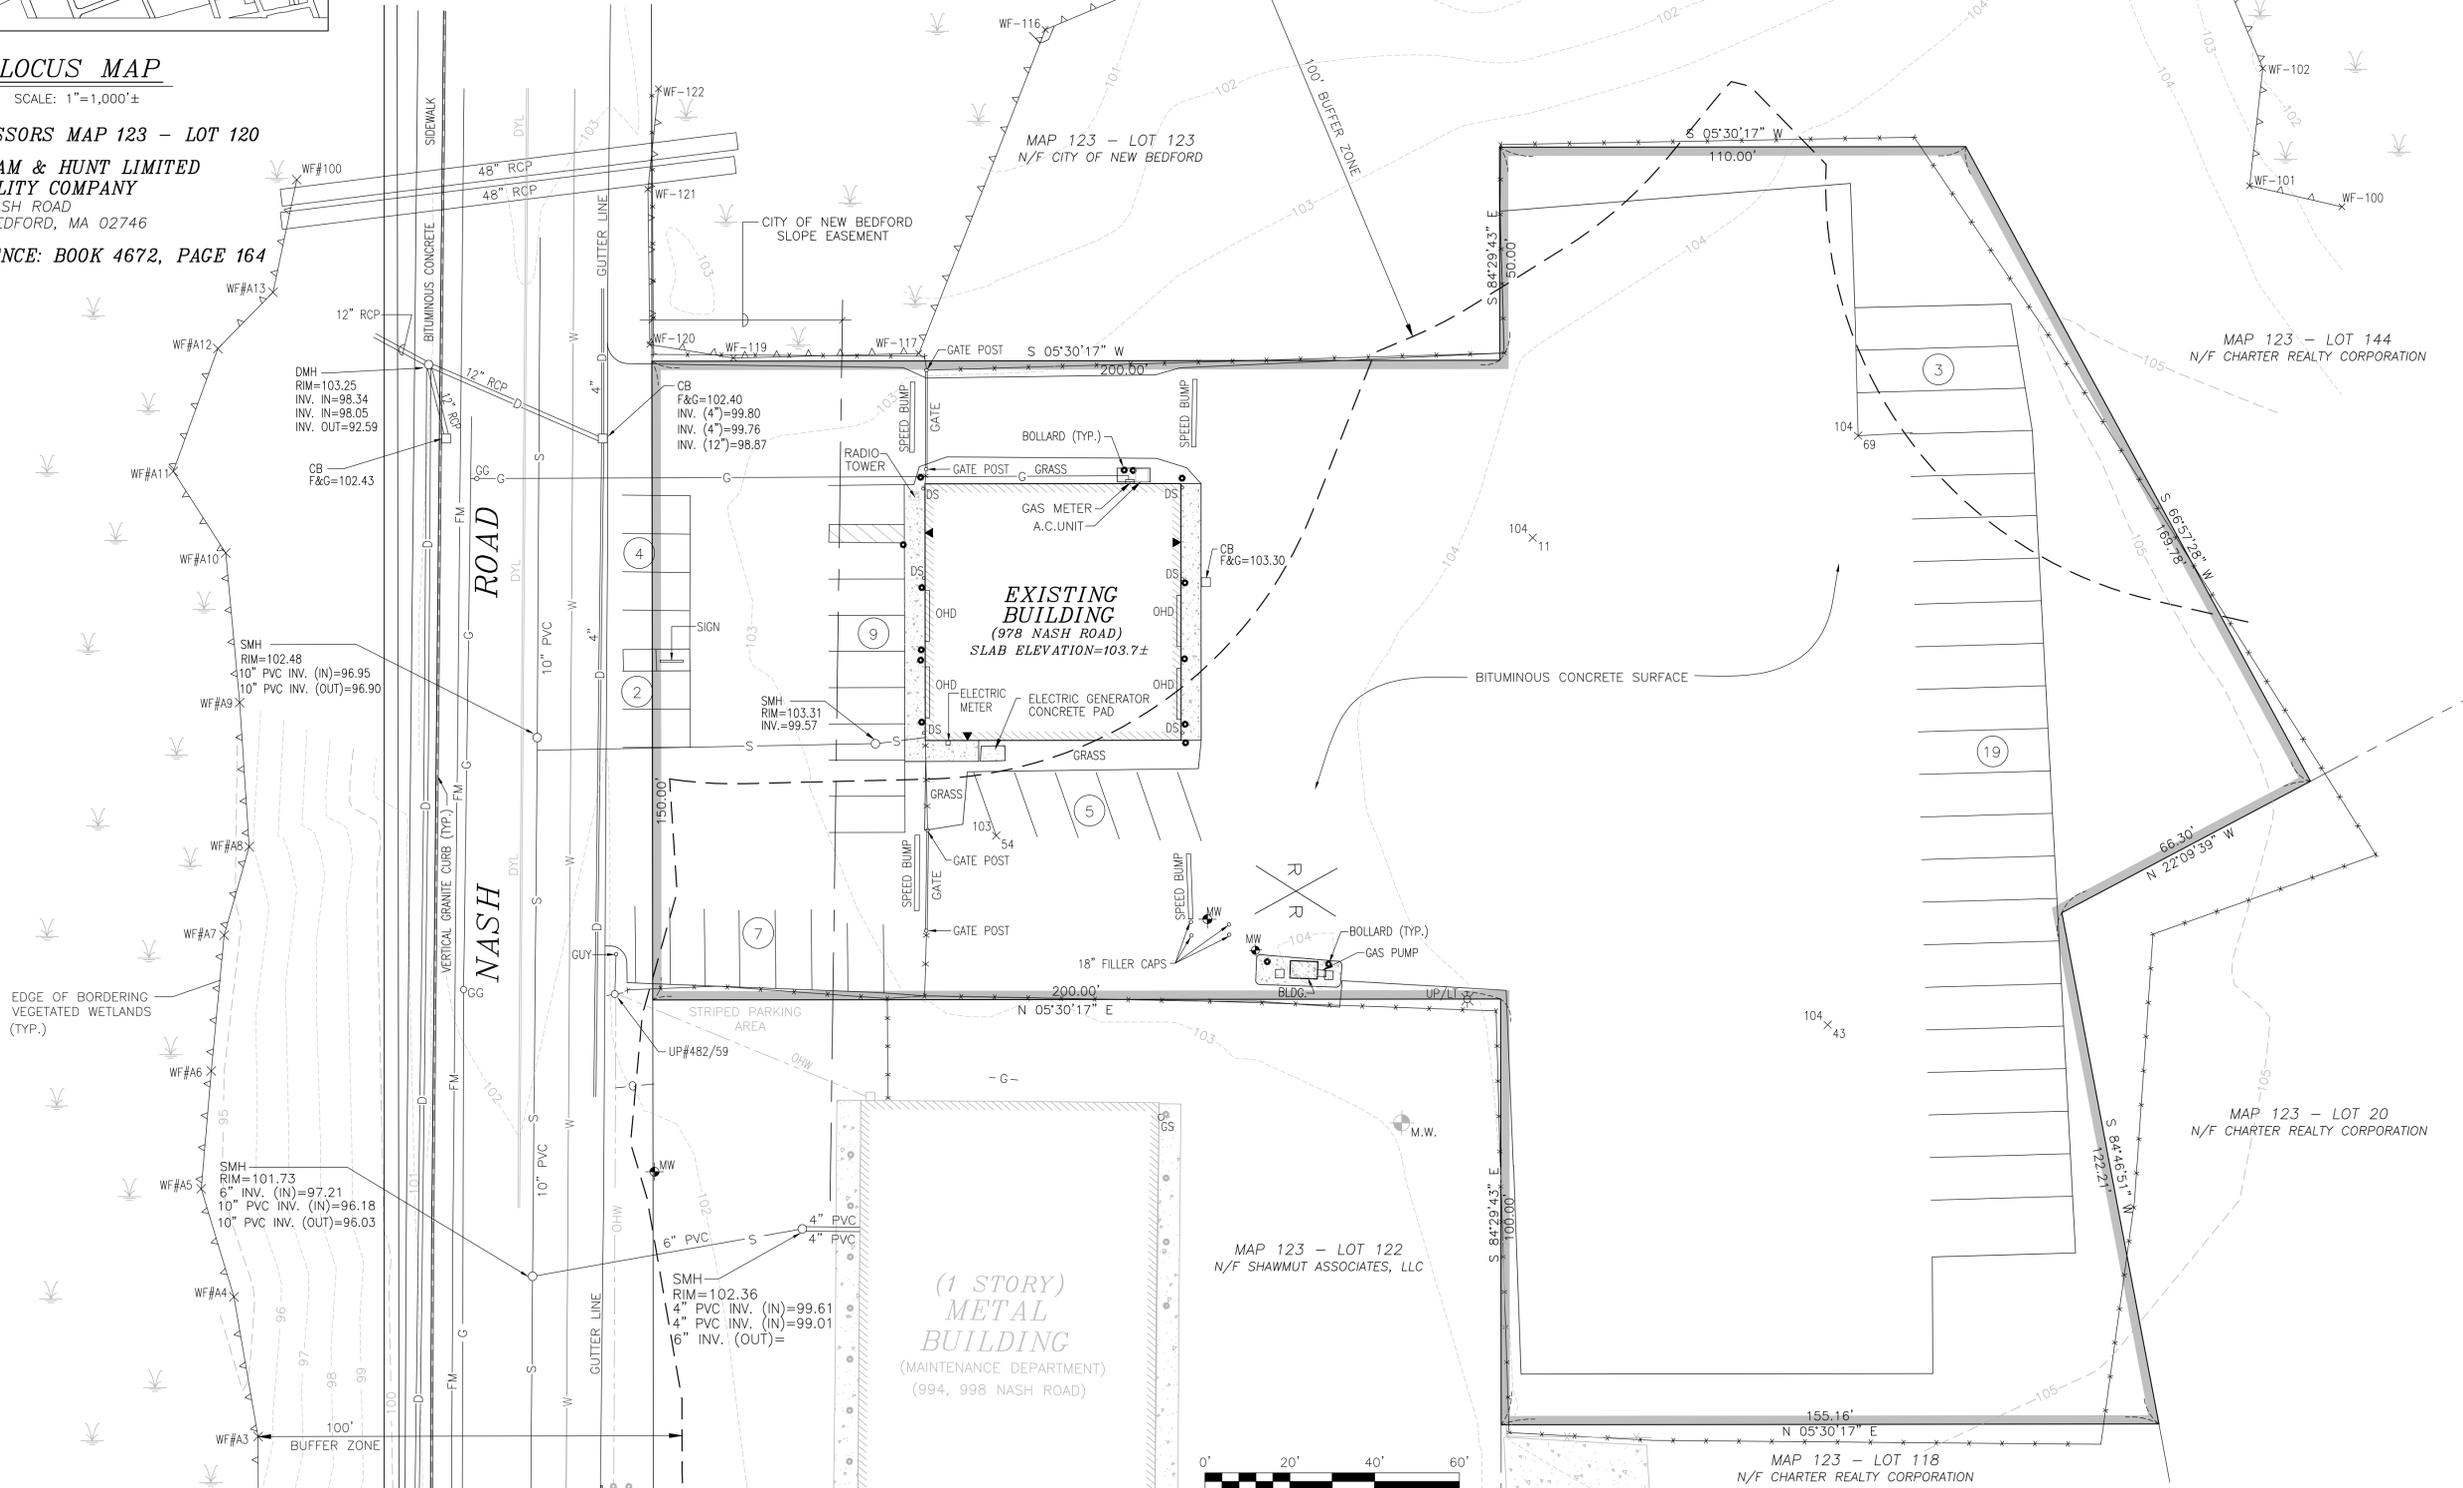

Revision Description	Date	No.	Scale	Date	Drawn	Checked	Approved	Sheet of	Drawing Number
			1"=20'	SEPTEMBER 1, 2015	BPL/NAD	SDG	SDG	1	EC-1

Project:	ASSESSORS MAP 123 LOT 120
Client:	978 NASH ROAD NEW BEDFORD, MASSACHUSETTS
Reliable Bus	
Existing Conditions	

SITEC, Inc. 400 Essex Street, 3rd Floor Barnstable, MA 02747 (508) 998-2125 FAX: (508) 998-7554 WWW.SITEC-ENGINEERING.COM	Acad. No. NB SE 15-1144 ECDWG File No. SE 15-1144
---	--

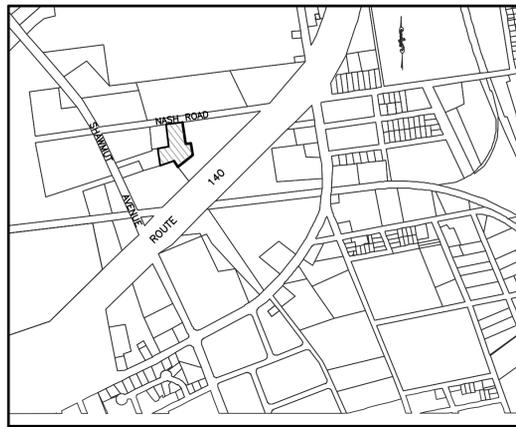

LOCUS MAP

SCALE: 1"=1,000'±


LOCUS: ASSESSORS MAP 123 - LOT 120

OWNER: GRAHAM & HUNT LIMITED
LIABILITY COMPANY
978 NASH ROAD
NEW BEDFORD, MA 02746

DEED REFERENCE: BOOK 4672, PAGE 164

LEGEND		
	PROPERTY LINE	CB □
	BUILDING ENTRANCE	DMH ○
	EXISTING CONTOUR	SMH ○
	DOUBLE YELLOW LINE	GG ○
	CHAIN LINK FENCE	UP ○
	OVERHEAD WIRES	MW ○
	GAS MAIN	104 43
	WATER MAIN	LP ○
	SEWER LINE	DS ○
	DRAINAGE LINE	WF ○
	NUMBER OF PARKING SPACES	
	SURFACE FLOW DIRECTION	
	CATCH BASIN	
	DRAIN MANHOLE	
	SEWER MANHOLE	
	GAS GATE VALVE	
	UTILITY POLE	
	MONITORING WELL	
	EXISTING SPOT GRADE	
	LIGHT POLE	
	DOWN SPOUT	
	EDGE OF BORDERING VEGETATED WETLANDS	

DRAINAGE PIPING SPECIFICATION
ALL PROPOSED PIPING TO TWELVE (12) DIAMETER HDPE ADS
N-12 ST IB (SOILTIGHT) PIPE OR EQUAL

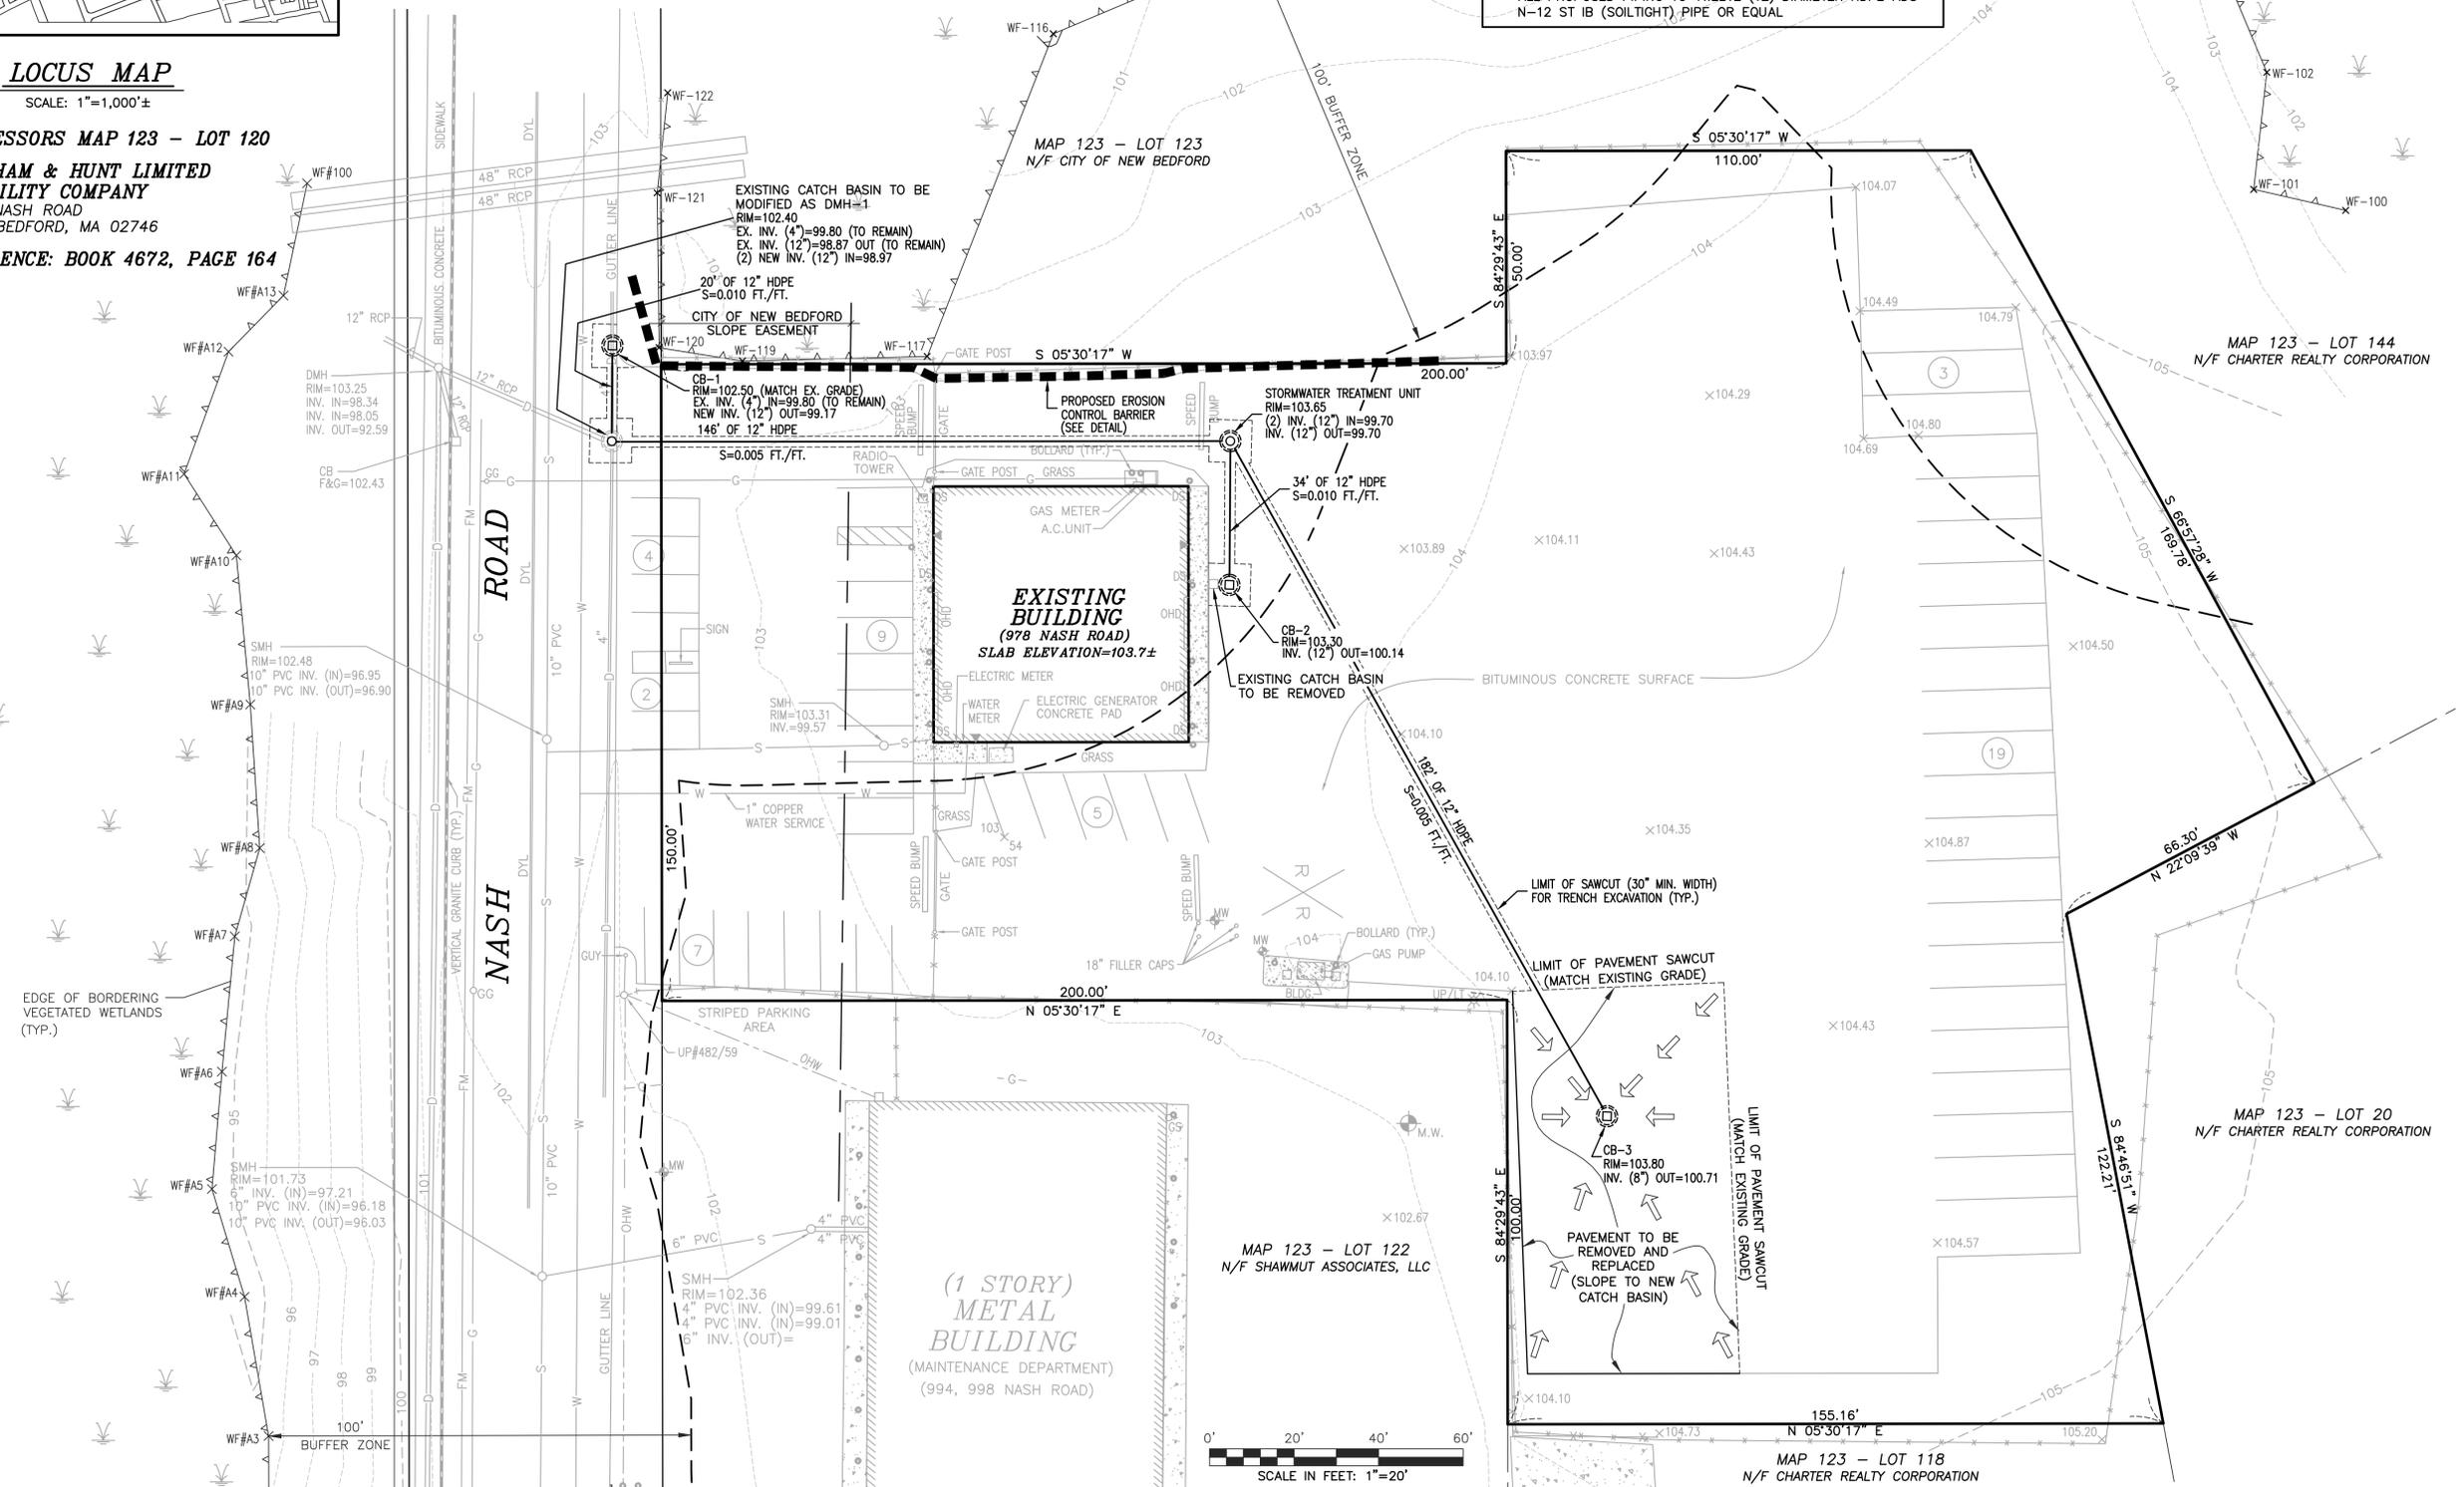

Chkd. Appvd.	Revision Description
ABT	RELOCATED CB-1 TO OUTSIDE DRIVEWAY
JAC	

No.	Date	Revision Description
1	MAR. 11, 2016	RELOCATED CB-1 TO OUTSIDE DRIVEWAY

Scale:	1"=20'
Date:	MAR. 2, 2016
Drawn:	JAC
Checked:	ABT
Approved:	JAC
Sheet:	1 of 2
Drawing Number:	SP-1

SITEC ENVIRONMENTAL
Civil and Environmental Engineering
Land Use Planning and Surveying
Hazardous and Solid Waste Consultants

789 Plain Street, Unit C
PHONE (781) 315-0100
FAX (781) 834-4783

Project: PARKING LOT DRAINAGE IMPROVEMENTS
Client: RELIABLE BUS 978 NASH ROAD NEW BEDFORD, MASSACHUSETTS
Drawing Title: SITE PLAN

