



**LifeStream, Inc.**  
 P.O. Box 50487  
 444 Myrtle Street  
 New Bedford, MA 02745  
 Tel: 508-993-1991 ~ Fax: 508-991-5228

**KENNETH R. FERREIRA  
 ENGINEERING, CO.**  
 PO BOX 1903  
 46 FOSTER STREET  
 NEW BEDFORD, MA 02741-1903  
 REGISTERED CIVIL ENGINEERS & SURVEYORS  
 TEL: 508-992-0020 ~ FAX: 508-992-3374



THE USER ACKNOWLEDGES THAT THE ENGINEER'S DOCUMENTS ARE INSTRUMENTS OF PROFESSIONAL SERVICE AND ARE BY COMMON COPYRIGHT. THIS DOCUMENT IS THE PROPERTY OF THE ENGINEER AND SHALL NOT BE MODIFIED, AMENDED, OR ALTERED IN ANY WAY. IT IS ISSUED FOR INFORMATION PURPOSES ONLY. THE USER AGREES TO HOLD HARMLESS, INDEMNIFY AND DEFEND THE ENGINEER AGAINST ANY AND ALL DAMAGES, CLAIMS, AND LOSSES, INCLUDING DEFENSE COSTS, ARISING OUT OF ANY REUSE OR COPYING OF THIS DOCUMENT FOR ANY USE OTHER THAN THE PROJECT FOR WHICH IT HAS BEEN PREPARED.

PROJECT

---

DRAWING TITLE

**PROPOSED LIGHTING & LANDSCAPING**

NOTE

**ISSUED FOR SITE PLAN REVIEW**

REVISIONS

NO.	DATE	DESCRIPTION

PROJECT NO. FE 2198  
 DATE OF ISSUE OCT. 10, 2014

DRAWN BY: K. WAINOR  
 CHECKED BY: K. FERREIRA

DRAWING NO. **C 3.0**

NAUSET

(PUBLIC ~ 50' WIDE)


STREET

MYRTLE

(PUBLIC ~ 50' WIDE)

STREET

BENCHMARK  
 TOP OF HYDRANT SPINDLE  
 ELEV. = 103.90

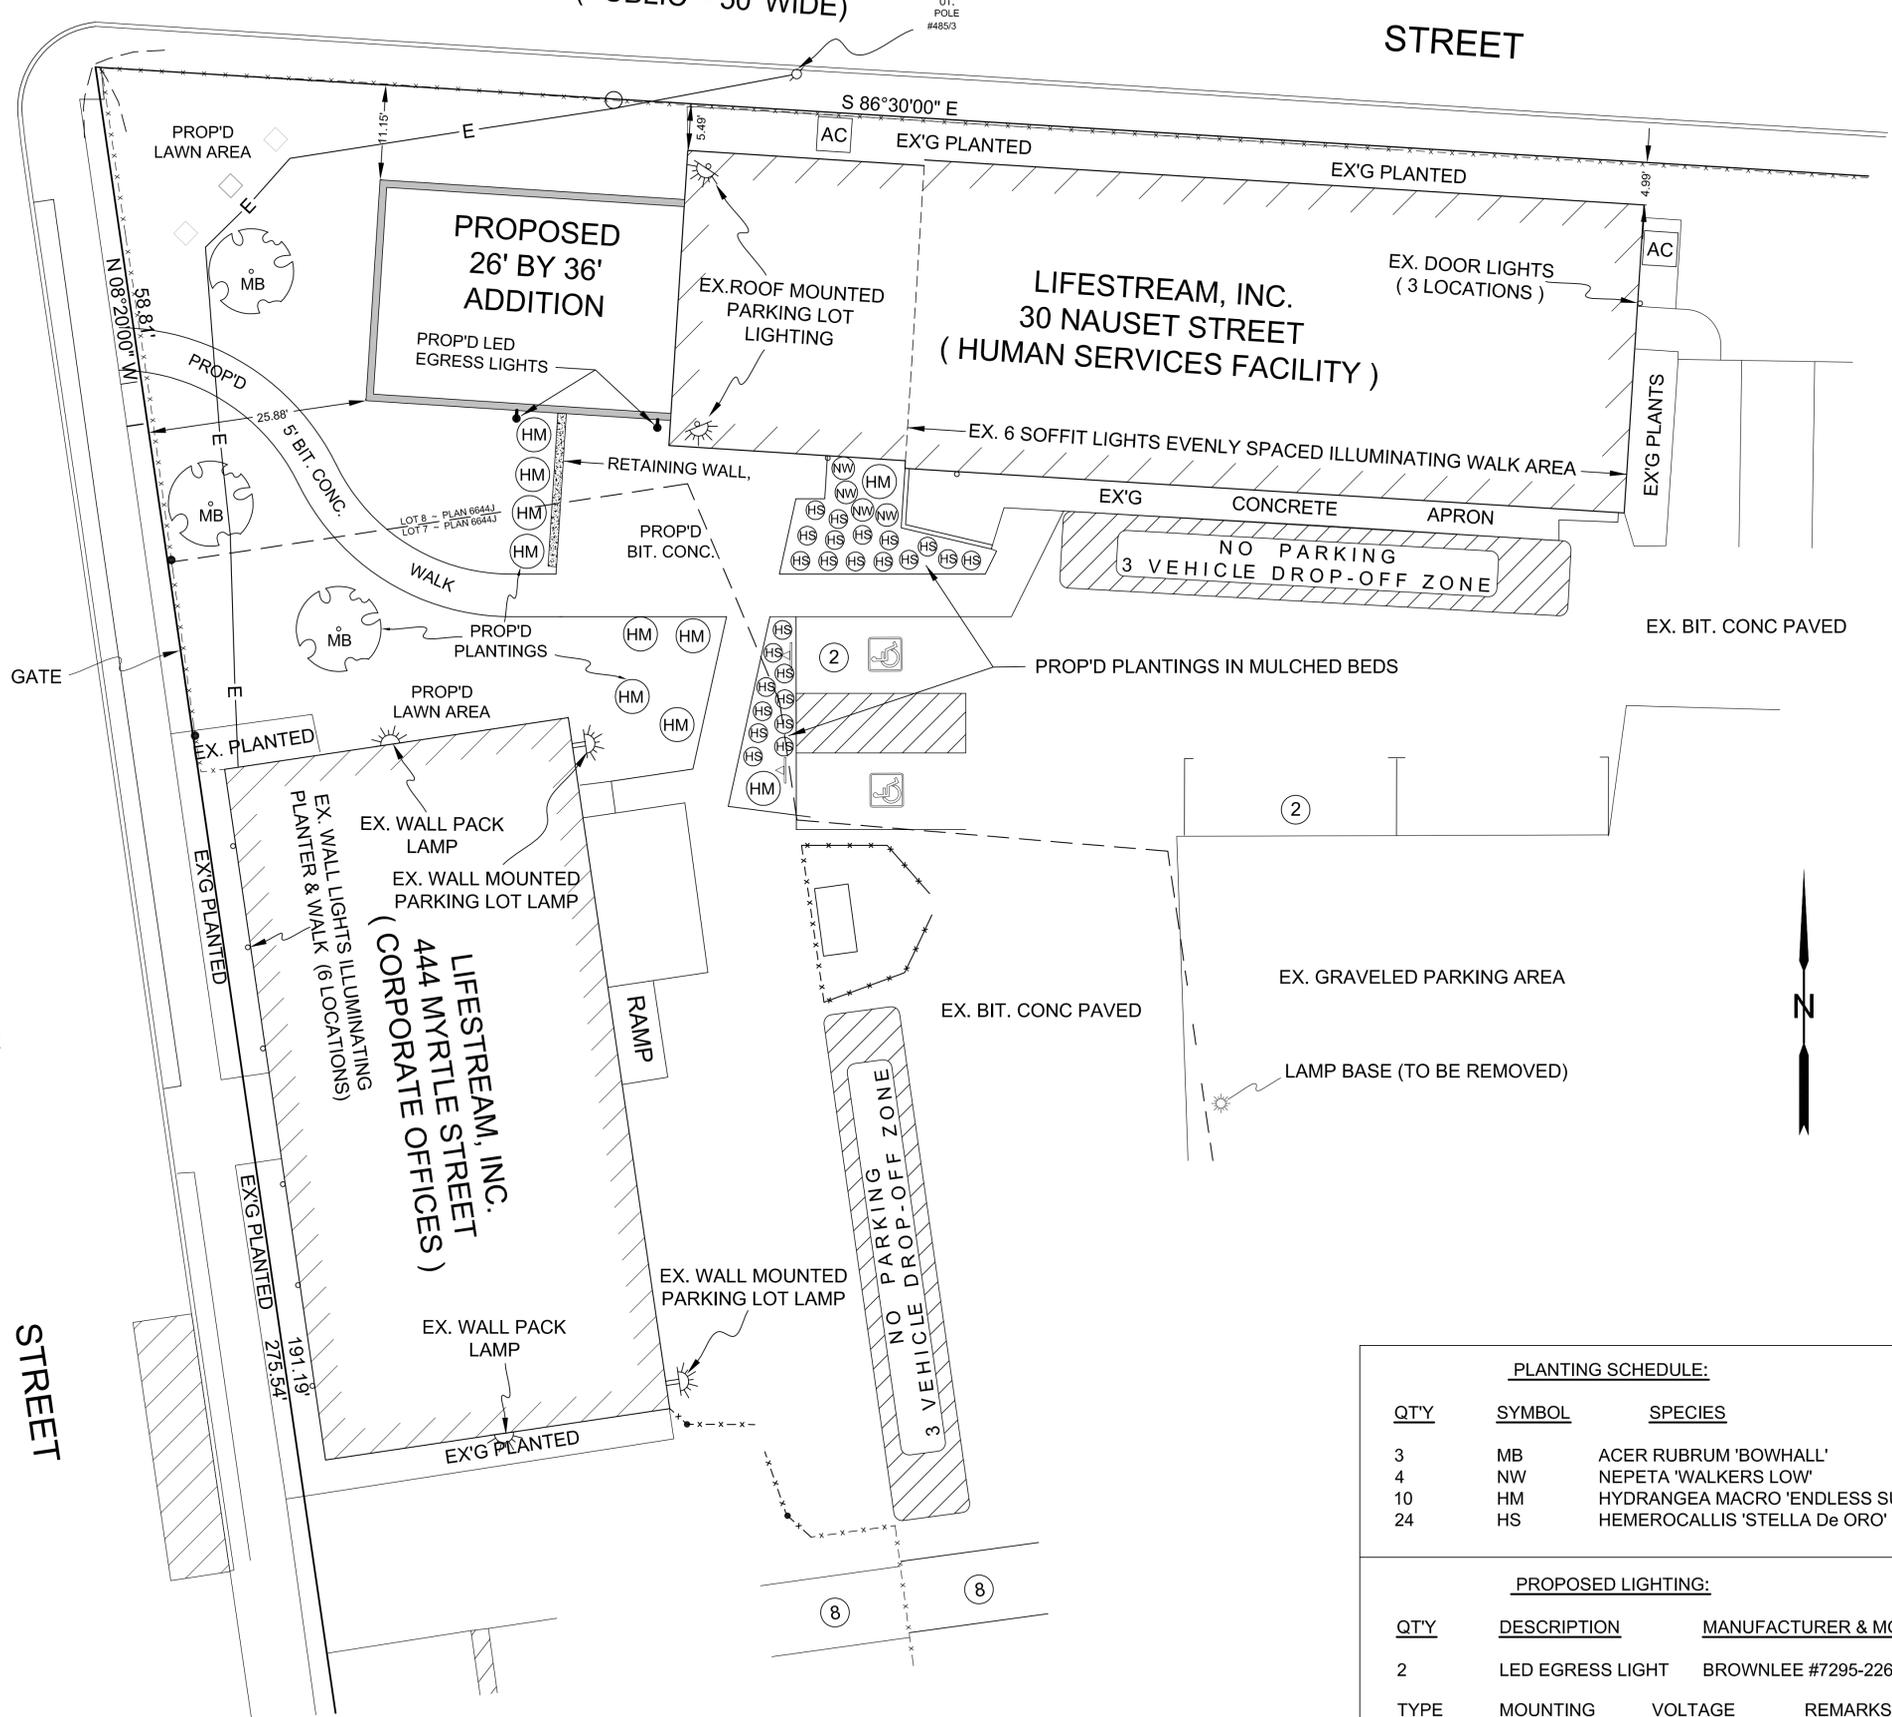

**PLANTING SCHEDULE:**

QTY	SYMBOL	SPECIES
3	MB	ACER RUBRUM 'BOWHALL'
4	NW	NEPETA 'WALKERS LOW'
10	HM	HYDRANGEA MACRO 'ENDLESS SUMMER'
24	HS	HEMEROCALLIS 'STELLA De ORO'

**PROPOSED LIGHTING:**

QTY	DESCRIPTION	MANUFACTURER & MODEL	
2	LED EGRESS LIGHT	BROWNLEE #7295-226Q-BB	
TYPE	MOUNTING	VOLTAGE	REMARKS
CFL	WALL	120	3500 K LAMPS